


HCL Imaging Division Scanning Facility

Widener DN90 Floor Plan — ISO 3664 compliant

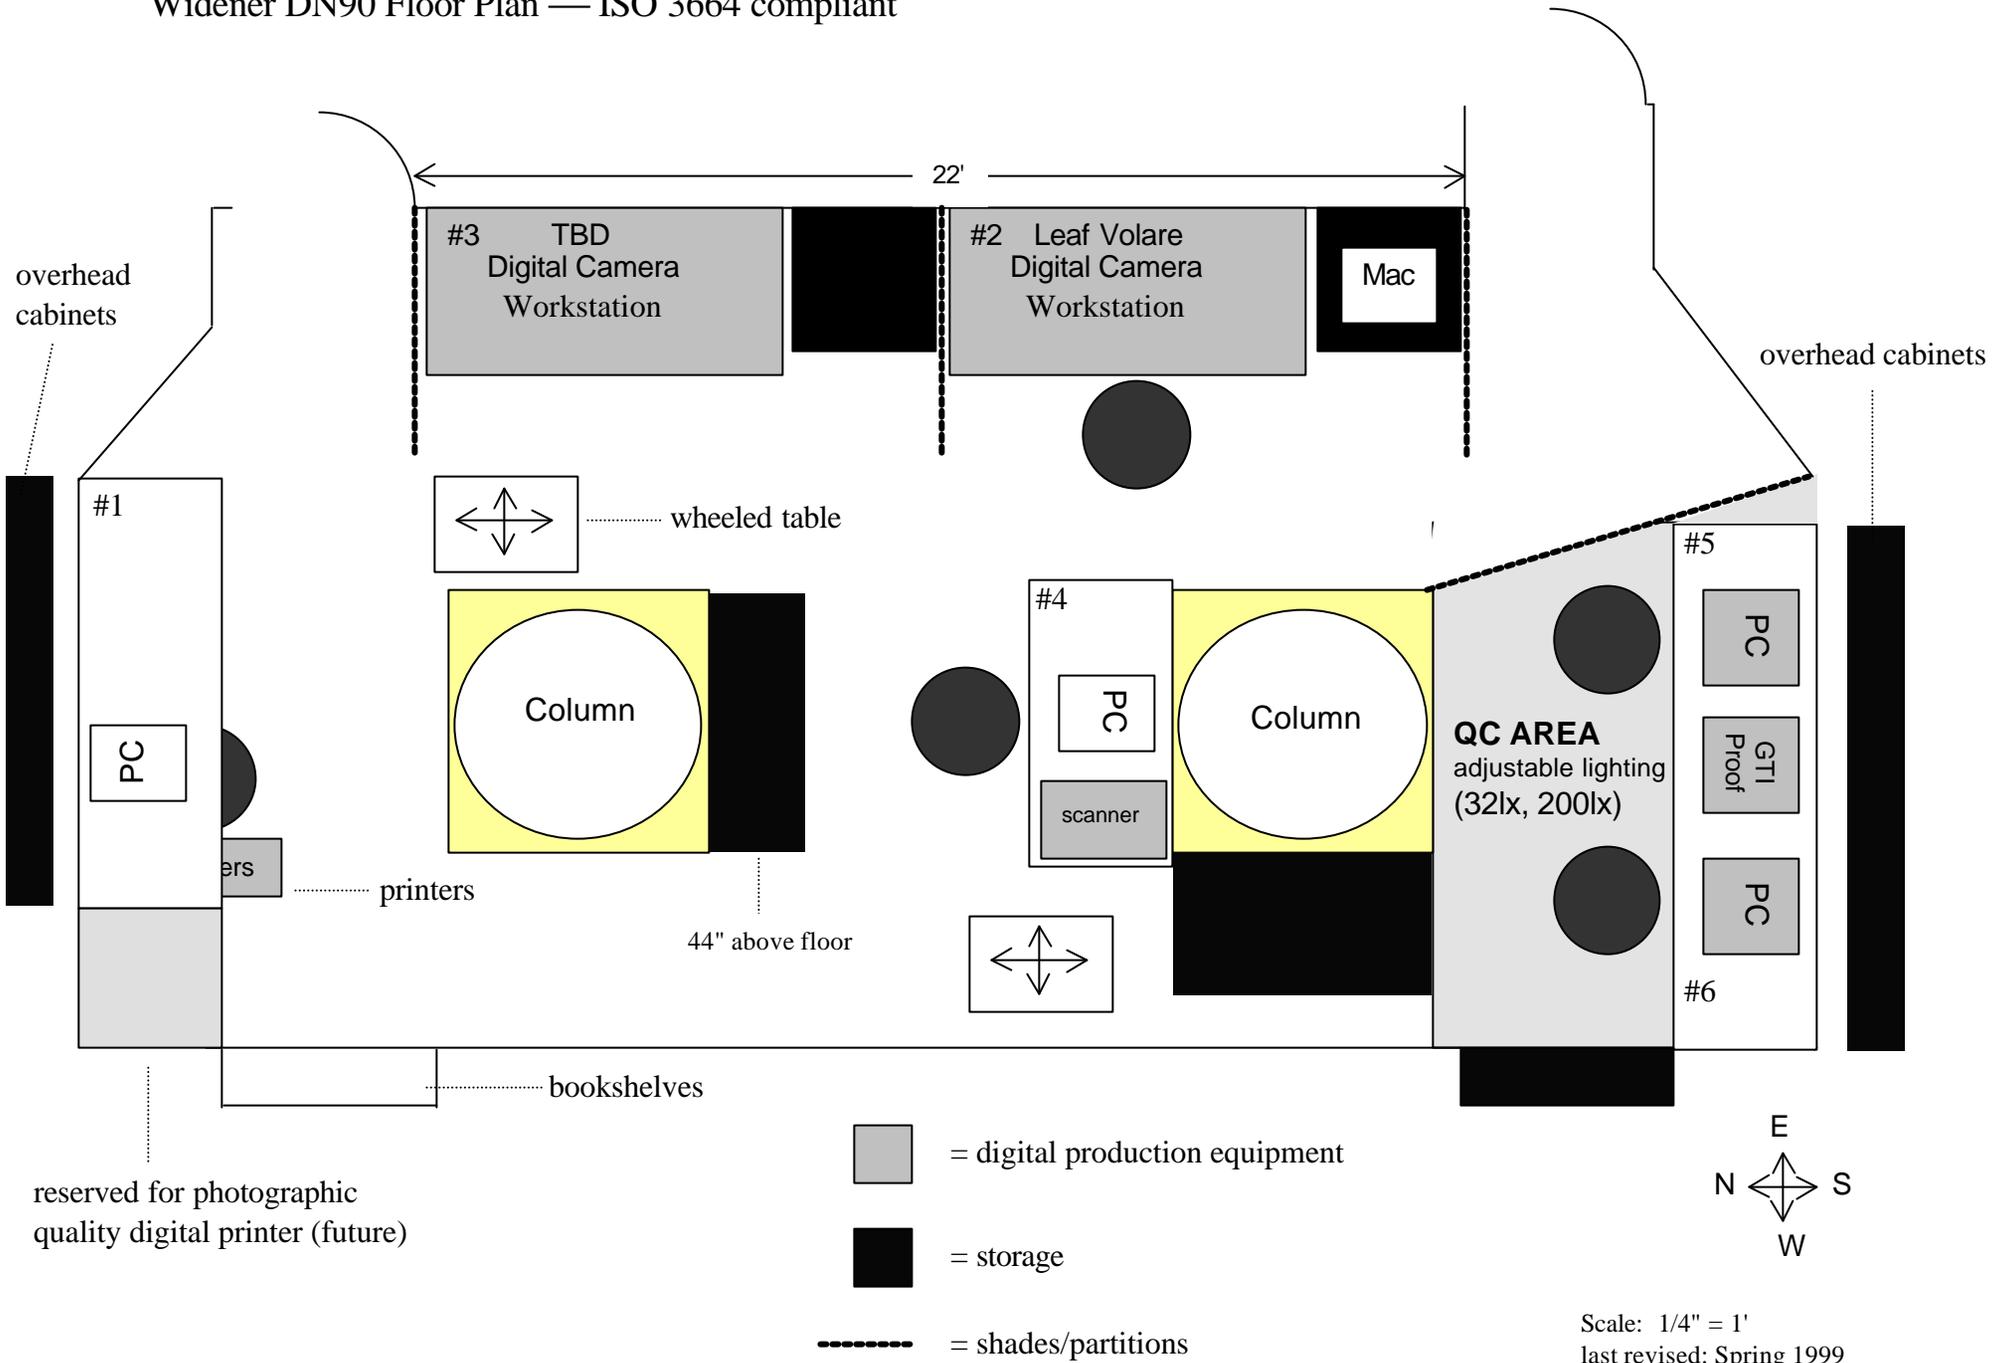

Scale: 1/4" = 1'
last revised: Spring 1999